

INDEX TO PLANS

ARCHITECTURAL

STRUCTURAL

ELECTRICAL

- BLYTHE MS**
- TITLE SHEET
 GP SITE PLAN, INDEX AND CODE ANALYSIS
- A0-1 ARCHITECTURAL ABBREVIATIONS, SYMBOLS
 A1-1 ENLARGED SITE PLAN
 A1-2 CANOPY ROOF PLAN & SECTION
 A1-2.1 REFLECTED CEILING PLAN
 A1-3 CANOPY ELEVATIONS
- VIDAL MS**
- A2-1 SITE PLAN
 A2-2 CANOPY FLOOR PLAN
 A2-2.1 ROOF PLAN AND SECTION
 A2-3 REFLECTED CEILING PLAN
 A2-4 CANOPY ELEVATIONS

- ST-1 LEGEND
 ST-2 CONCRETE STANDARDS
 ST-3 CANOPY TYPICAL DETAILS
 ST-4 CANOPY TYPICAL DETAILS
 ST-5 FOOTING TYPICAL DETAILS
 ST1-0 DESIGN CRITERIA & DETAIL NOTES
 ST1-1 FUEL PUMP FOUNDATION & CANOPY
 ST1-2 ROOF PLAN
 ST1-3 CANOPY SECTIONS
 ST1-4 FOOTING DETAILS
 ST2-0 DESIGN CRITERIA AND DETAIL NOTES
 ST2-1 FUEL PUMP FOUNDATION AND CANOPY
 ST2-2 FUEL PUMP FOUNDATION AND CANOPY
 ST2-3 CANOPY SECTIONS
 ST2-4 FOOTING DETAILS

- EE0-1 LEGEND
 EE0-2 NOTES AND ABBREVIATIONS
- BLYTHE MAINTENANCE STATION**
- EE1-1 OUTDOOR LIGHTING COMPLIANCE FORMS 1
 EE1-2 OUTDOOR LIGHTING COMPLIANCE FORMS 2
 EE1-3 SITE PLAN
 EE1-4 POWER AND LIGHTING PLAN
 EE1-5 DETAILS 1
 EE1-6 DETAILS 2
- VIDAL MAINTENANCE STATION**
- EE2-1 OUTDOOR LIGHTING COMPLIANCE FORMS 1
 EE2-2 OUTDOOR LIGHTING COMPLIANCE FORMS. 2
 EE2-3 SITE PLAN
 EE2-4 POWER AND LIGHTING PLAN
 EE2-5 DETAILS

DIST.	COUNTY	LOCATION CODE	POST MILES TOTAL PROJECT	SHEET NO.	TOTAL SHEETS
08	Riv, SBd	5701, 5731		2	40

LICENSED ARCHITECT _____ DATE _____

3-11-13
 PLANS APPROVAL DATE

The State of California or its officers or agents shall not be responsible for the accuracy or completeness of electronic copies of this plan sheet.

ACCESSIBILITY DESIGN APPROVAL STAMP
 DOT / DES / OTA
 PROJECT ID: 0812000207
 EXEMPT
 Reviewed by: Y. A. WANG
 Date: 12-06-12

CALIFORNIA STATE FIRE MARSHAL APPROVED
 Approval of this plan does not authorize or approve any omission or deviation from applicable regulations. Final approval is subject to field inspection. One set of approved plans shall be available on the project site at all times.
 Reviewed by: FRANCIS SOLICH
 Approval date: 12-11-12


CODE ANALYSIS

- DESIGN GUIDE:**
- 2010 CALIFORNIA BUILDING CODE
 - 2010 CALIFORNIA FIRE CODE
 - 2010 CALIFORNIA MECHANICAL CODE
 - 2010 CALIFORNIA ELECTRICAL CODE
 - 2010 CALIFORNIA ENERGY CODE (TITLE 24)
 - 2010 AMERICANS WITH DISABILITIES ACT STANDARDS

BLDG. OCCUPANCY: GROUP U
OCCUPANT LOAD: NOT APPLICABLE

AREA: 36'x54'=1944 SQUARE FEET (ROOF PROJECTION)

CONSTRUCTION TYPE:	TYPE II B
ACTUAL CANOPY HEIGHT:	16 FEET
NUMBER OF EXITS REQ'D:	NOT APPLICABLE
CORRIDOR FIRE RATING:	NOT APPLICABLE
FIRE SPRINKLER:	NOT APPLICABLE
FIRE ALARM:	NOT APPLICABLE
SMOKE CONTROL SYSTEM:	NOT APPLICABLE

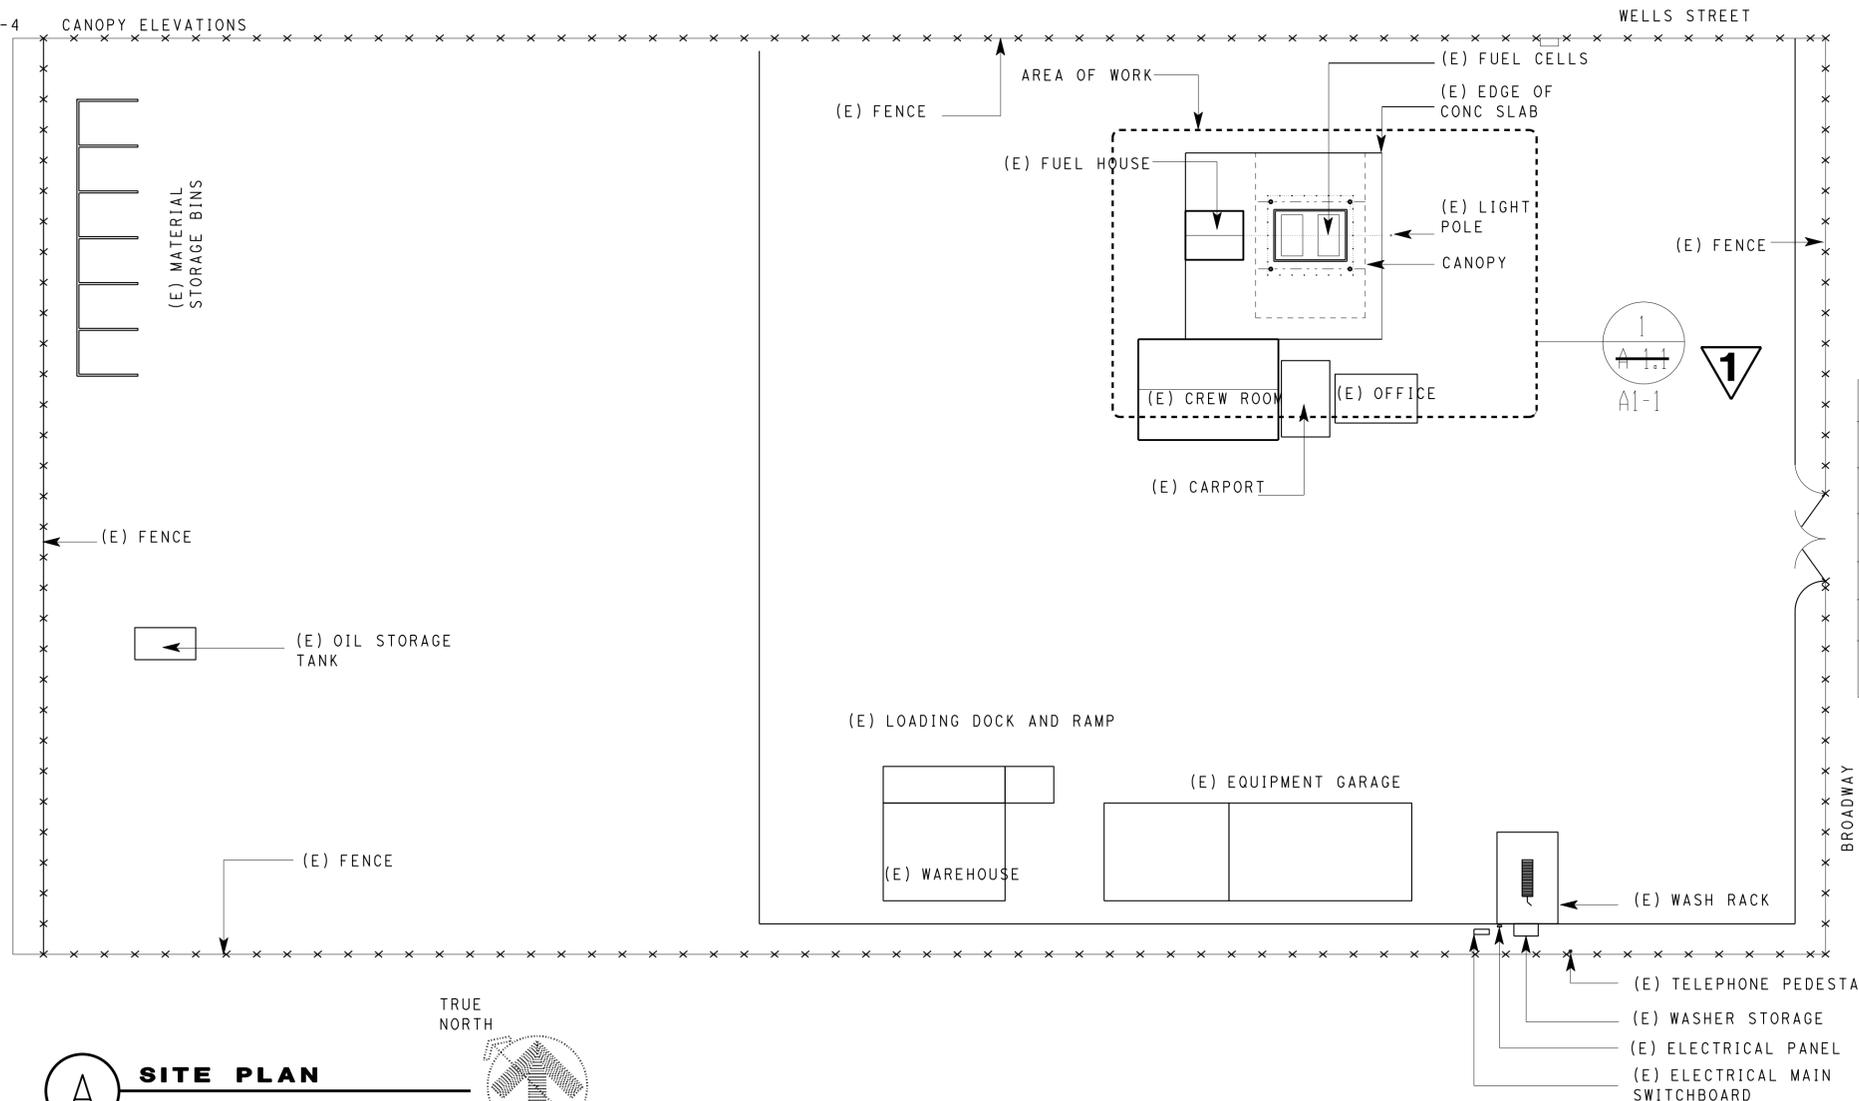

A SITE PLAN
 SCALE 1" : 30'

1 REVISED PER ADDENDUM No. 1 DATED MAY 3, 2013

DESIGNERS: DOUG LOWE DRAWN BY: C. SANCHEZ, DESIGN ARCHITECT	CHECKED BY: C. FAUST STRUCTURAL REVIEW: C. FAUST	SHEET LEGEND A-I ARCHITECTURAL M-I MECHANICAL P-I WATER SUPPLY ST-1 STRUCTURAL EE-1 ELECTRICAL SS-1 SANITARY	STATE OF CALIFORNIA DEPARTMENT OF TRANSPORTATION	DIVISION OF ENGINEERING SERVICES ARCHITECTURAL AND STRUCTURAL DESIGN	BRIDGE NO. 56M5701 POST MILE 111.7	BLYTHE MAINTENANCE STATION SITE PLAN, INDEX AND CODE ANALYSIS	SHEET GP OF	
ORIGINAL SCALE IN INCHES FOR REDUCED PLANS 0 1 2 3						DISREGARD PRINTS BEARING EARLIER REVISION DATES	REVISION DATES (PRELIMINARY STAGE ONLY)	SHEET OF


gp-genp1n.add DS OSD Imperial Rev. 10/07 25-APR-2013 11:05

DIST.	COUNTY	LOCATION CODE	POST MILES TOTAL PROJECT	SHEET NO.	TOTAL SHEETS
08	Riv, SBd	5701, 5731		7	40


 LICENSED ARCHITECT		DATE
3-11-13 PLANS APPROVAL DATE		
<i>The State of California or its officers or agents shall not be responsible for the accuracy or completeness of electronic copies of this plan sheet.</i>		




ACCESSIBILITY DESIGN APPROVAL STAMP DOT / DES / OTA PROJECT ID: 0812000207 EXEMPT Reviewed by: Y. A. WANG Date: 12-06-12	CALIFORNIA STATE FIRE MARSHAL APPROVED Approval of this plan does not authorize or approve any omission or deviation from applicable regulations. Final approval is subject to field inspection. One set of approved plans shall be available on the project site at all times. Reviewed by: FRANCIS SOLICH Approval date: 12-11-12
--	---

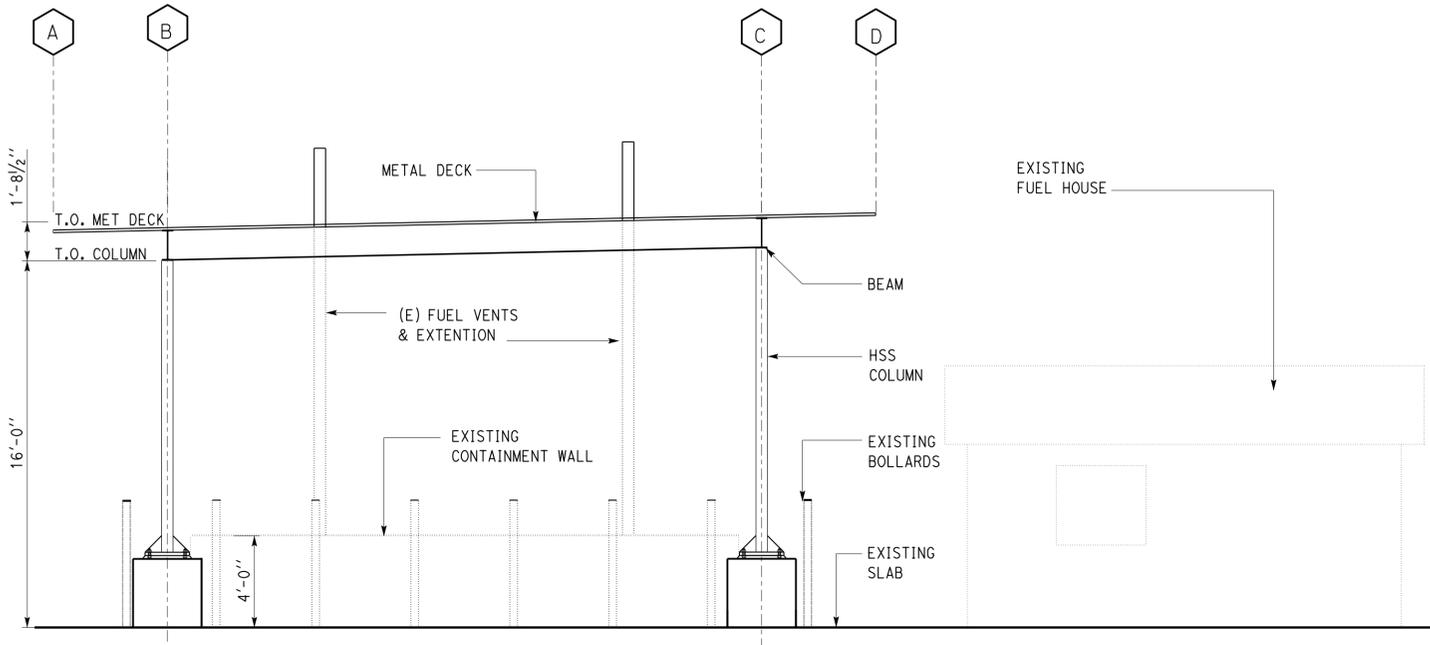


1 CANOPY NORTH ELEVATION
SCALE: 1/4" = 1'-0"

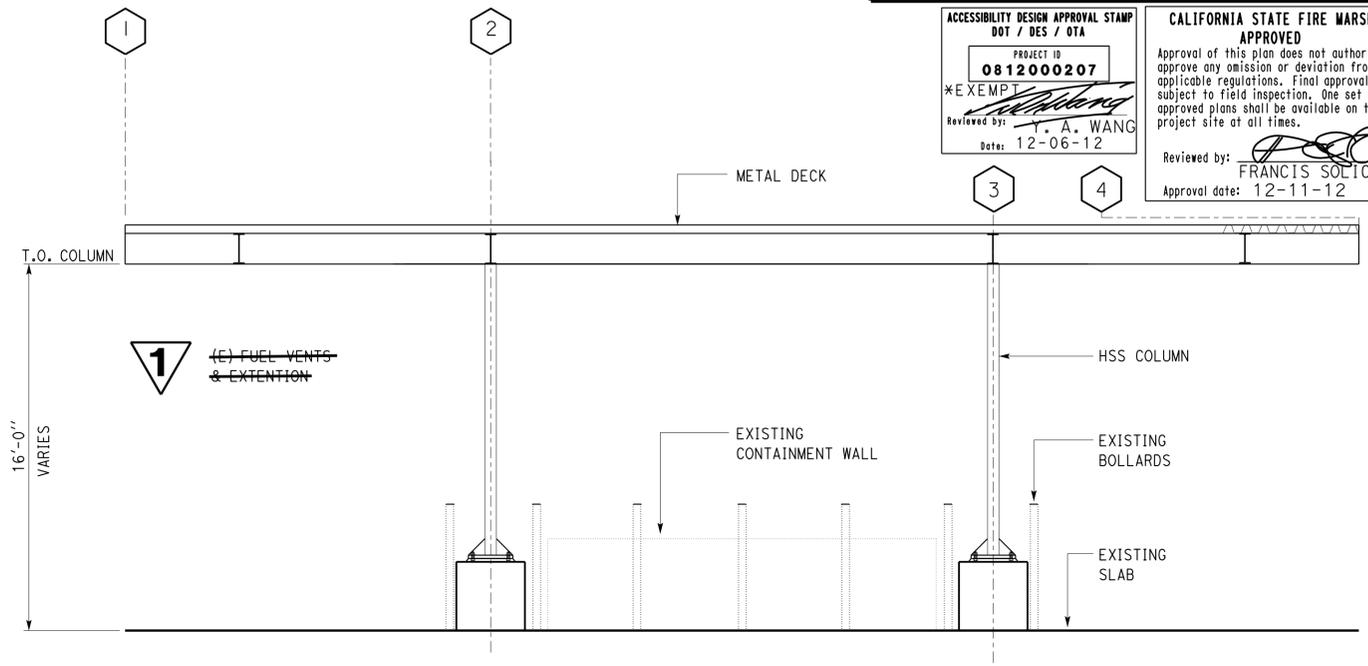

3 CANOPY EAST ELEVATION
SCALE: 1/4" = 1'-0"

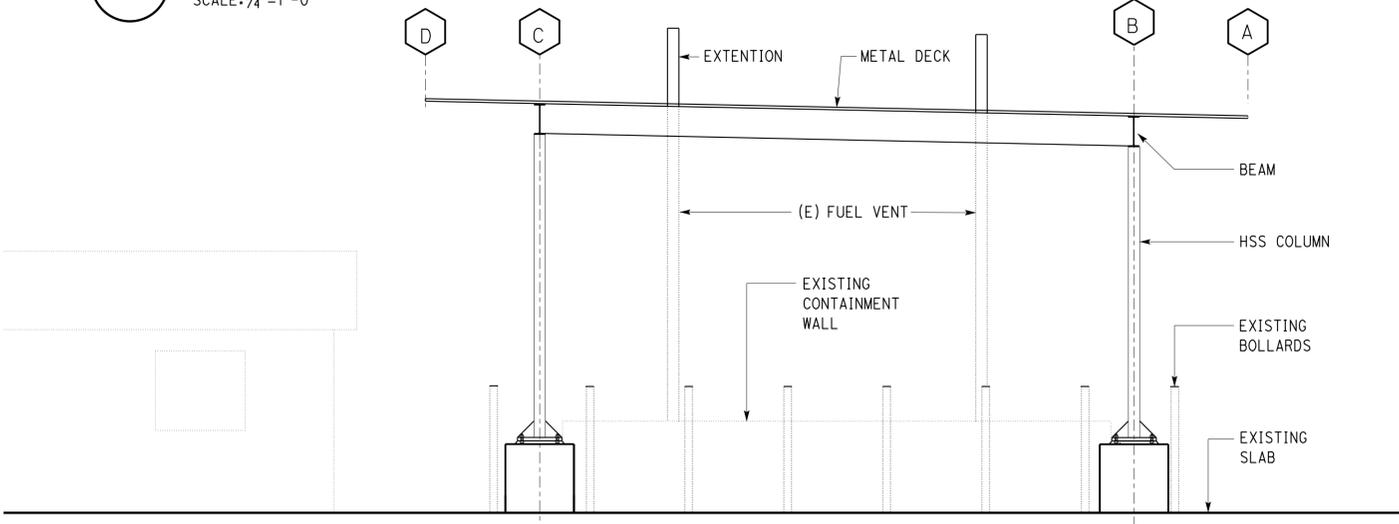

2 CANOPY SOUTH ELEVATION
SCALE: 1/4" = 1'-0"

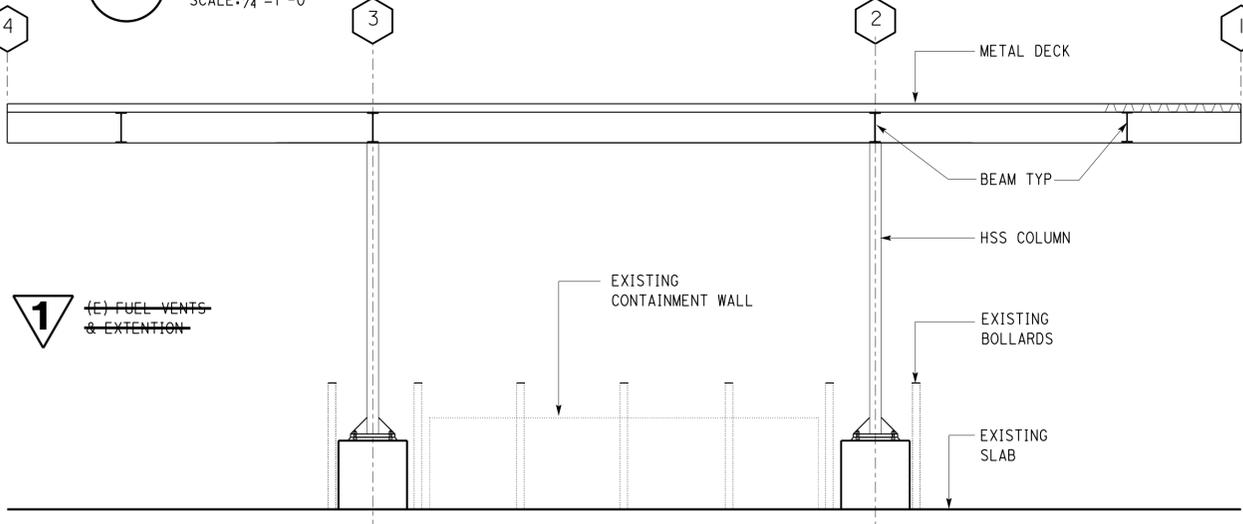


4 CANOPY WEST ELEVATION
SCALE: 1/4" = 1'-0"

1 REVISED PER ADDENDUM No. 1 DATED MAY 3, 2013

a1-3-elevs.add DS OSD Imperial Rev. 10/07 25-APR-2013 11:05	DESIGN BY Carlos Sanchez CHECKED C. Faust	STATE OF CALIFORNIA DEPARTMENT OF TRANSPORTATION	DIVISION OF ENGINEERING SERVICES ARCHITECTURAL AND STRUCTURAL DESIGN	BRIDGE NO. 56M5701	BLTYHE MAINTENANCE STATION	SHEET A1-3 OF
	DETAILS BY Carlos Sanchez CHECKED C. Faust			POST MILE 111.7		
	QUANTITIES BY CHECKED	ORIGINAL SCALE IN INCHES FOR REDUCED PLANS 0 1 2 3	CU EA 08 12000207	DISREGARD PRINTS BEARING EARLIER REVISION DATES	REVISION DATES (PRELIMINARY STAGE ONLY)	SHEET OF


25-APR-2013 11:05

DIST.	COUNTY	LOCATION CODE	POST MILES TOTAL PROJECT	SHEET NO.	TOTAL SHEETS
08	Riv, SBd	5701, 5731		11	40
 LICENSED ARCHITECT			DATE		
					
3-11-13					
PLANS APPROVAL DATE					
<i>The State of California or its officers or agents shall not be responsible for the accuracy or completeness of electronic copies of this plan sheet.</i>					

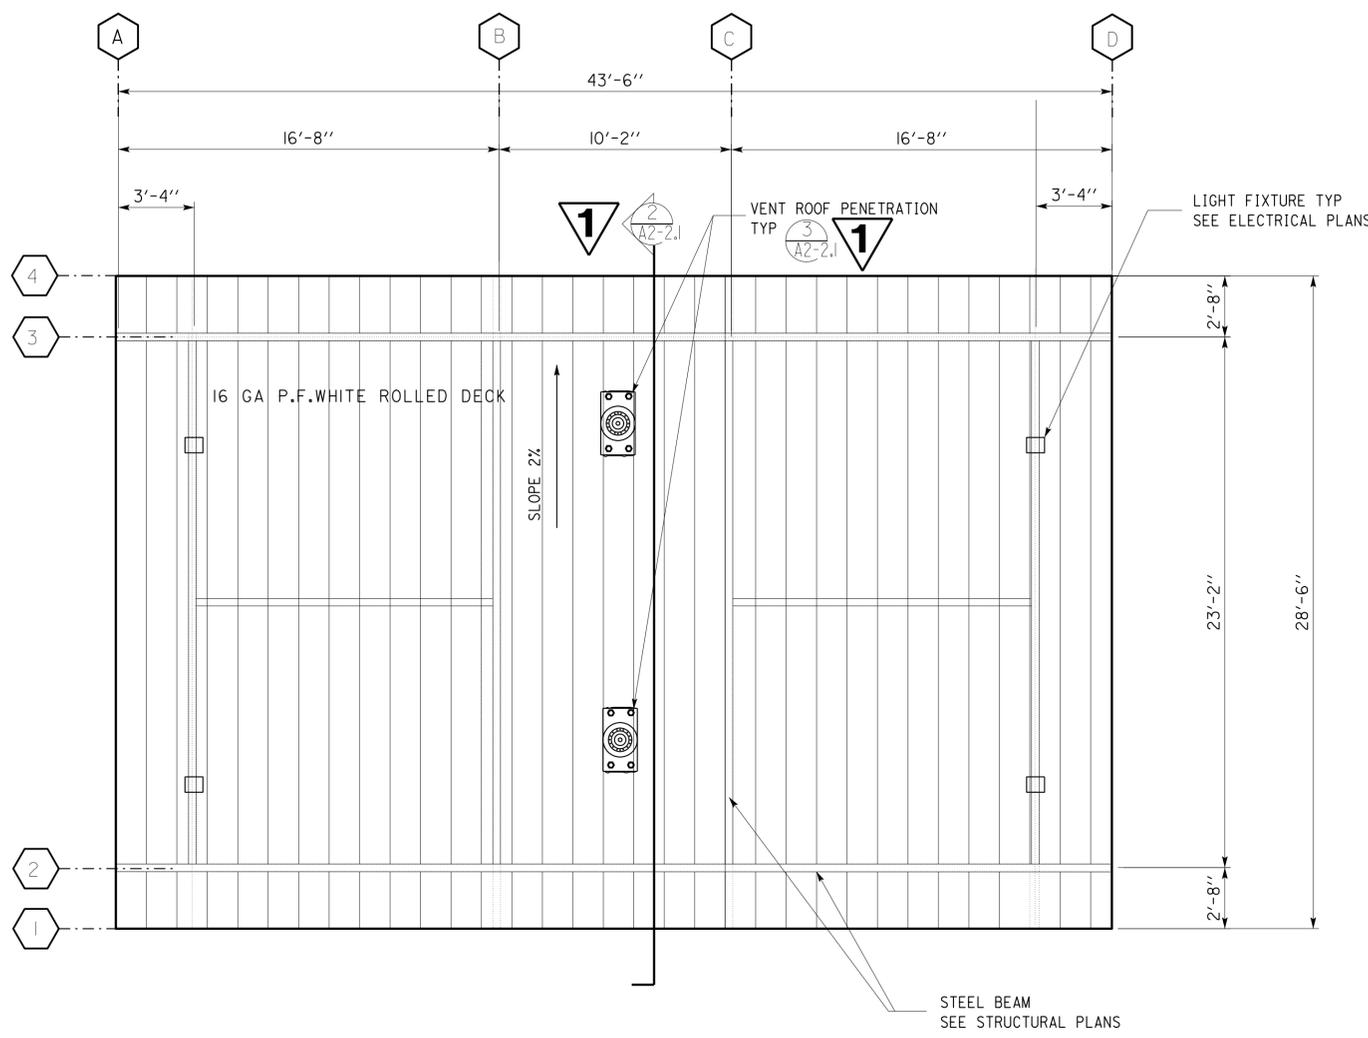

CALIFORNIA STATE FIRE MARSHAL APPROVED

 Approval of this plan does not authorize or approve any omission or deviation from applicable regulations. Final approval is subject to field inspection. One set of approved plans shall be available on the project site at all times.

Reviewed by: 
FRANCIS SOLICH
 Approval date: 12-11-12

1 CANOPY REFLECTED CEILING PLAN
 SCALE: 1/4"=1'-0"



1 REVISED PER ADDENDUM No. 1 DATED MAY 3, 2013

a2-3-rf-pln.add DS OSD Imperial Rev. 10/07 25-APR-2013 11:05	DESIGN	BY Carlos Sanchez	CHECKED C. Faust	STATE OF CALIFORNIA DEPARTMENT OF TRANSPORTATION	DIVISION OF ENGINEERING SERVICES ARCHITECTURAL AND STRUCTURAL DESIGN	BRIDGE NO.	56M5701	VIDAL MAINTENANCE STATION REFLECTED CEILING PLAN	SHEET	OF	
	DETAILS	BY Carlos Sanchez	CHECKED C. Faust			POST MILE	111.7		11	40	
QUANTITIES	BY	CHECKED	CU EA			08 12000207	REVISION DATES (PRELIMINARY STAGE ONLY)				
ORIGINAL SCALE IN INCHES FOR REDUCED PLANS: 0 1 2 3										DISREGARD PRINTS BEARING EARLIER REVISION DATES →	

25-APR-2013 11:05